




ENLARGED PLUMBING PLAN "A-1"
WASTE AND VENT
 SCALE: 1/4" = 1' - 0"

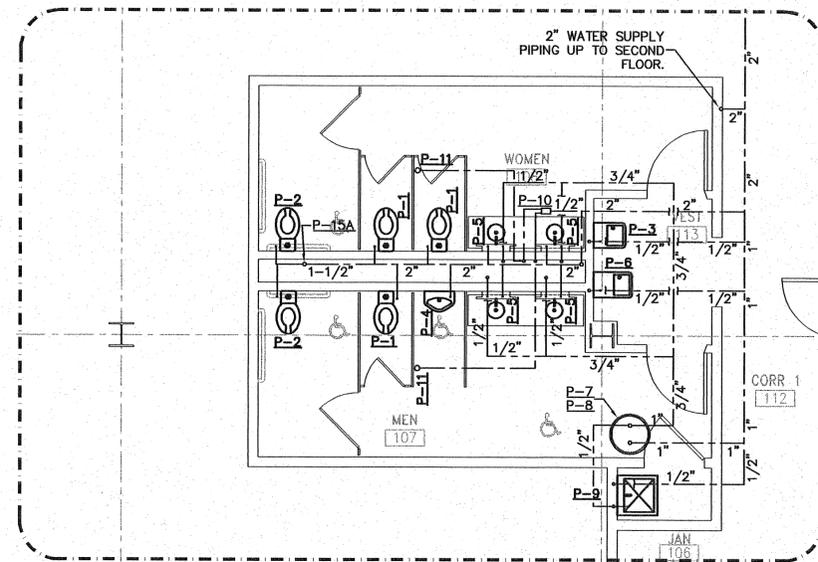

ENLARGED PLUMBING PLAN "A-1"
WATER SUPPLY
 SCALE: 1/4" = 1' - 0"

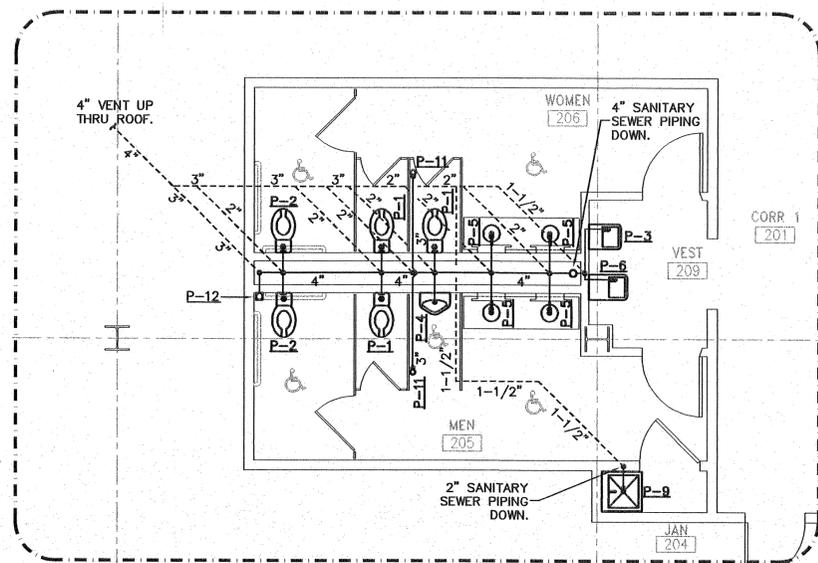

ENLARGED PLUMBING PLAN "A-2"
WASTE AND VENT
 SCALE: 1/4" = 1' - 0"

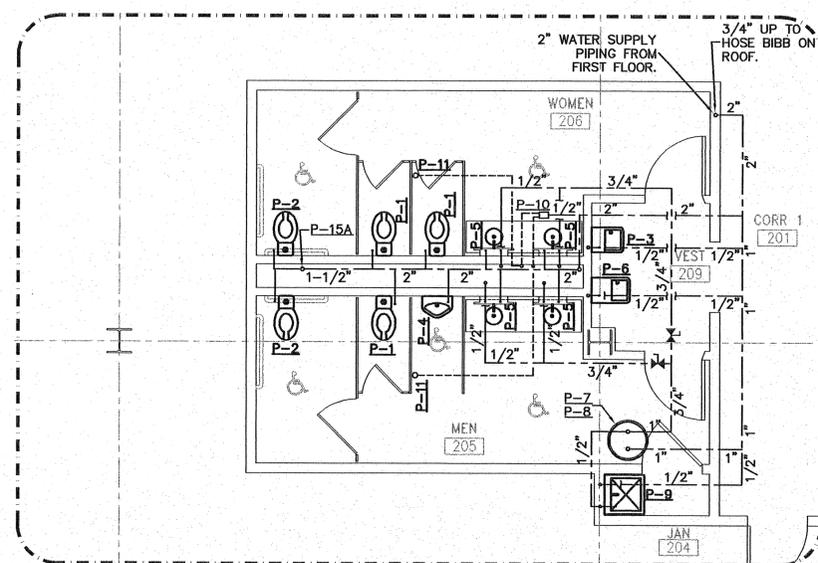

ENLARGED PLUMBING PLAN "A-2"
WATER SUPPLY
 SCALE: 1/4" = 1' - 0"

REVISIONS		
No.	Date	Description
1	4/27/06	PLUMBING REVISIONS

MORELLI
MECHANICAL
ENGINEERING
CONSULTING
 ASSOCIATES, INC.
 Heating & Air Conditioning, Inc.
"THE PROBLEM SOLVERS"

Job Number : 105261
 Designed : 11/11/05
 Plot Date : 27 April 2006
 Drawn :
 Approved By :

THIS DRAWING IS THE PROPERTY OF MECHANICAL ENGINEERING CONSULTING ASSOCIATES, INC. UNAUTHORIZED USE OF ANY KIND, INCLUDING USE ON OTHER PROJECTS IS PROHIBITED.

Project: **OFFICES AT BELLE HALL BUILDING TWO MOUNT PLEASANT, SC**
 Sheet Title: **ENLARGED PLUMBING PLANS**

M.E.C.A.
 Mechanical
 Engineering
 Consulting
 Associates, Inc.
 P.O. Box 50644
 Columbia, South Carolina
 Phone: (803) 765-9421

Sheet No. **P2.1**
 of 5
 Project No. **105261**